

YORKTOWN RNC GROUND MOUNT SOLAR

283.8 KW-DC SOLAR PV SYSTEM
2300 CATHERINE STREET
YORKTOWN, NY 10598



ECOGY ENERGY
315 FLATBUSH AVENUE #393
BROOKLYN, NY 11217
assetmanagement@ecogyenergy.com
(718)-304-0945

ECOGY NY XII LLC


Project Name:
**YORKTOWN RNC
283.8 kW-DC PV SYSTEM
GROUND MOUNT**

Project Site:
**2300 CATHERINE STREET
YORKTOWN, NY 10598**

Account No: xxxxx
New Service Case #: xxxxx

LOCATION MAP
SCALE: NTS

SATELLITE MAP
SCALE: NTS

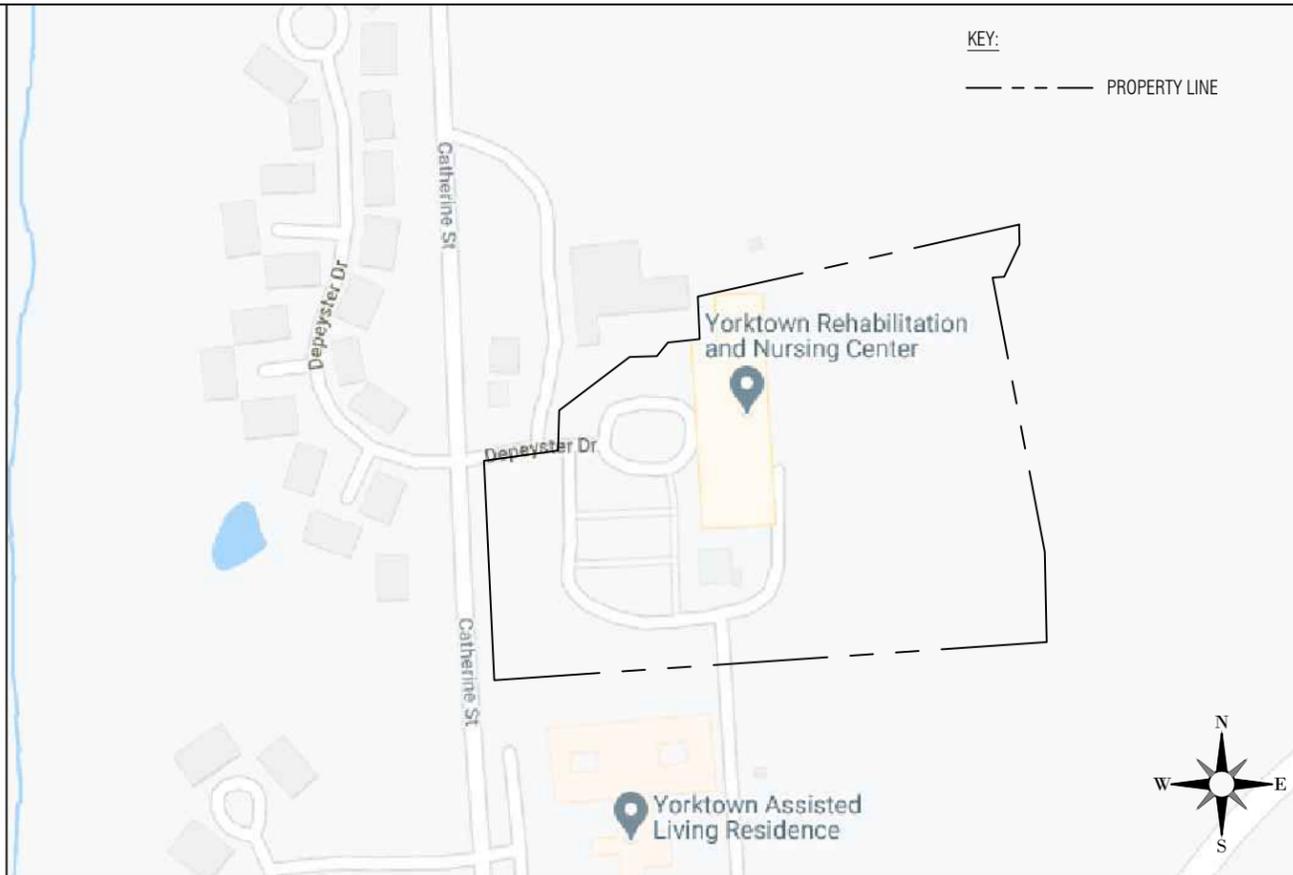

#	REVISION DESCRIPTION	DATE	BY

SCOPE OF WORK:

TO INSTALL A SOLAR PHOTOVOLTAIC (PV) SYSTEM LOCATED ON THE GROUND WITH THE POWER GENERATED BY THE PV SYSTEM WILL BE INTERCONNECTED WITH THE UTILITY GRID.

THE PV SYSTEM DOES NOT INCLUDE STORAGE BATTERIES.

SYSTEM SUMMARY:

283.8 kW DC / 259.8 kW-AC
TILT ANGLE = 20°
AZIMUTH = 178°

EQUIPMENT:

MODULES:
628 - LONGI 445W
INVERTERS:
(6) - SOLAREEDGE SE43.3 K-US INVERTERS
RACKING:
T.B.D.
DAS:
ECOGY ECONODE

SITE SPECIFICATIONS:

WIND EXPOSURE:
CATEGORY X
DESIGN WIND SPEED:
XXX
GROUND SNOW LOAD:
XXX PSF
BUILDING OCCUPANCY:
XXX

Professional Stamp

SHEET NAME:

TITLE SHEET

PROJECT NUMBER: XXXX	DRAWN BY: DQP	CHECKED BY: ---
DATE: 06/25/2021	DWG. NUMBER: G-001	
SHEET NUMBER: - of -		

REVIEW PLAN SET
ISSUE DATE: 09/22/2021

DRAWING LIST


DWG. NO.	DRAWING TITLE
G-001	TITLE SHEET
PV-100	SITE PLAN
PV-200	GROUND MOUNT ELEVATION
L-100	TREE WORK PLAN

SYMBOLS LEGEND:

-  INDIVIDUAL TREE TO BE REMOVED
-  GROUP OF TREES TO BE REMOVED

GENERAL NOTESE:

SEE TREE INVENTORY DATED 6/22/2021 FOR DETAILS ON INDIVIDUAL TREES
 ONLY TREES PROPOSED TO BE REMOVED IDENTIFIED ON DRAWING

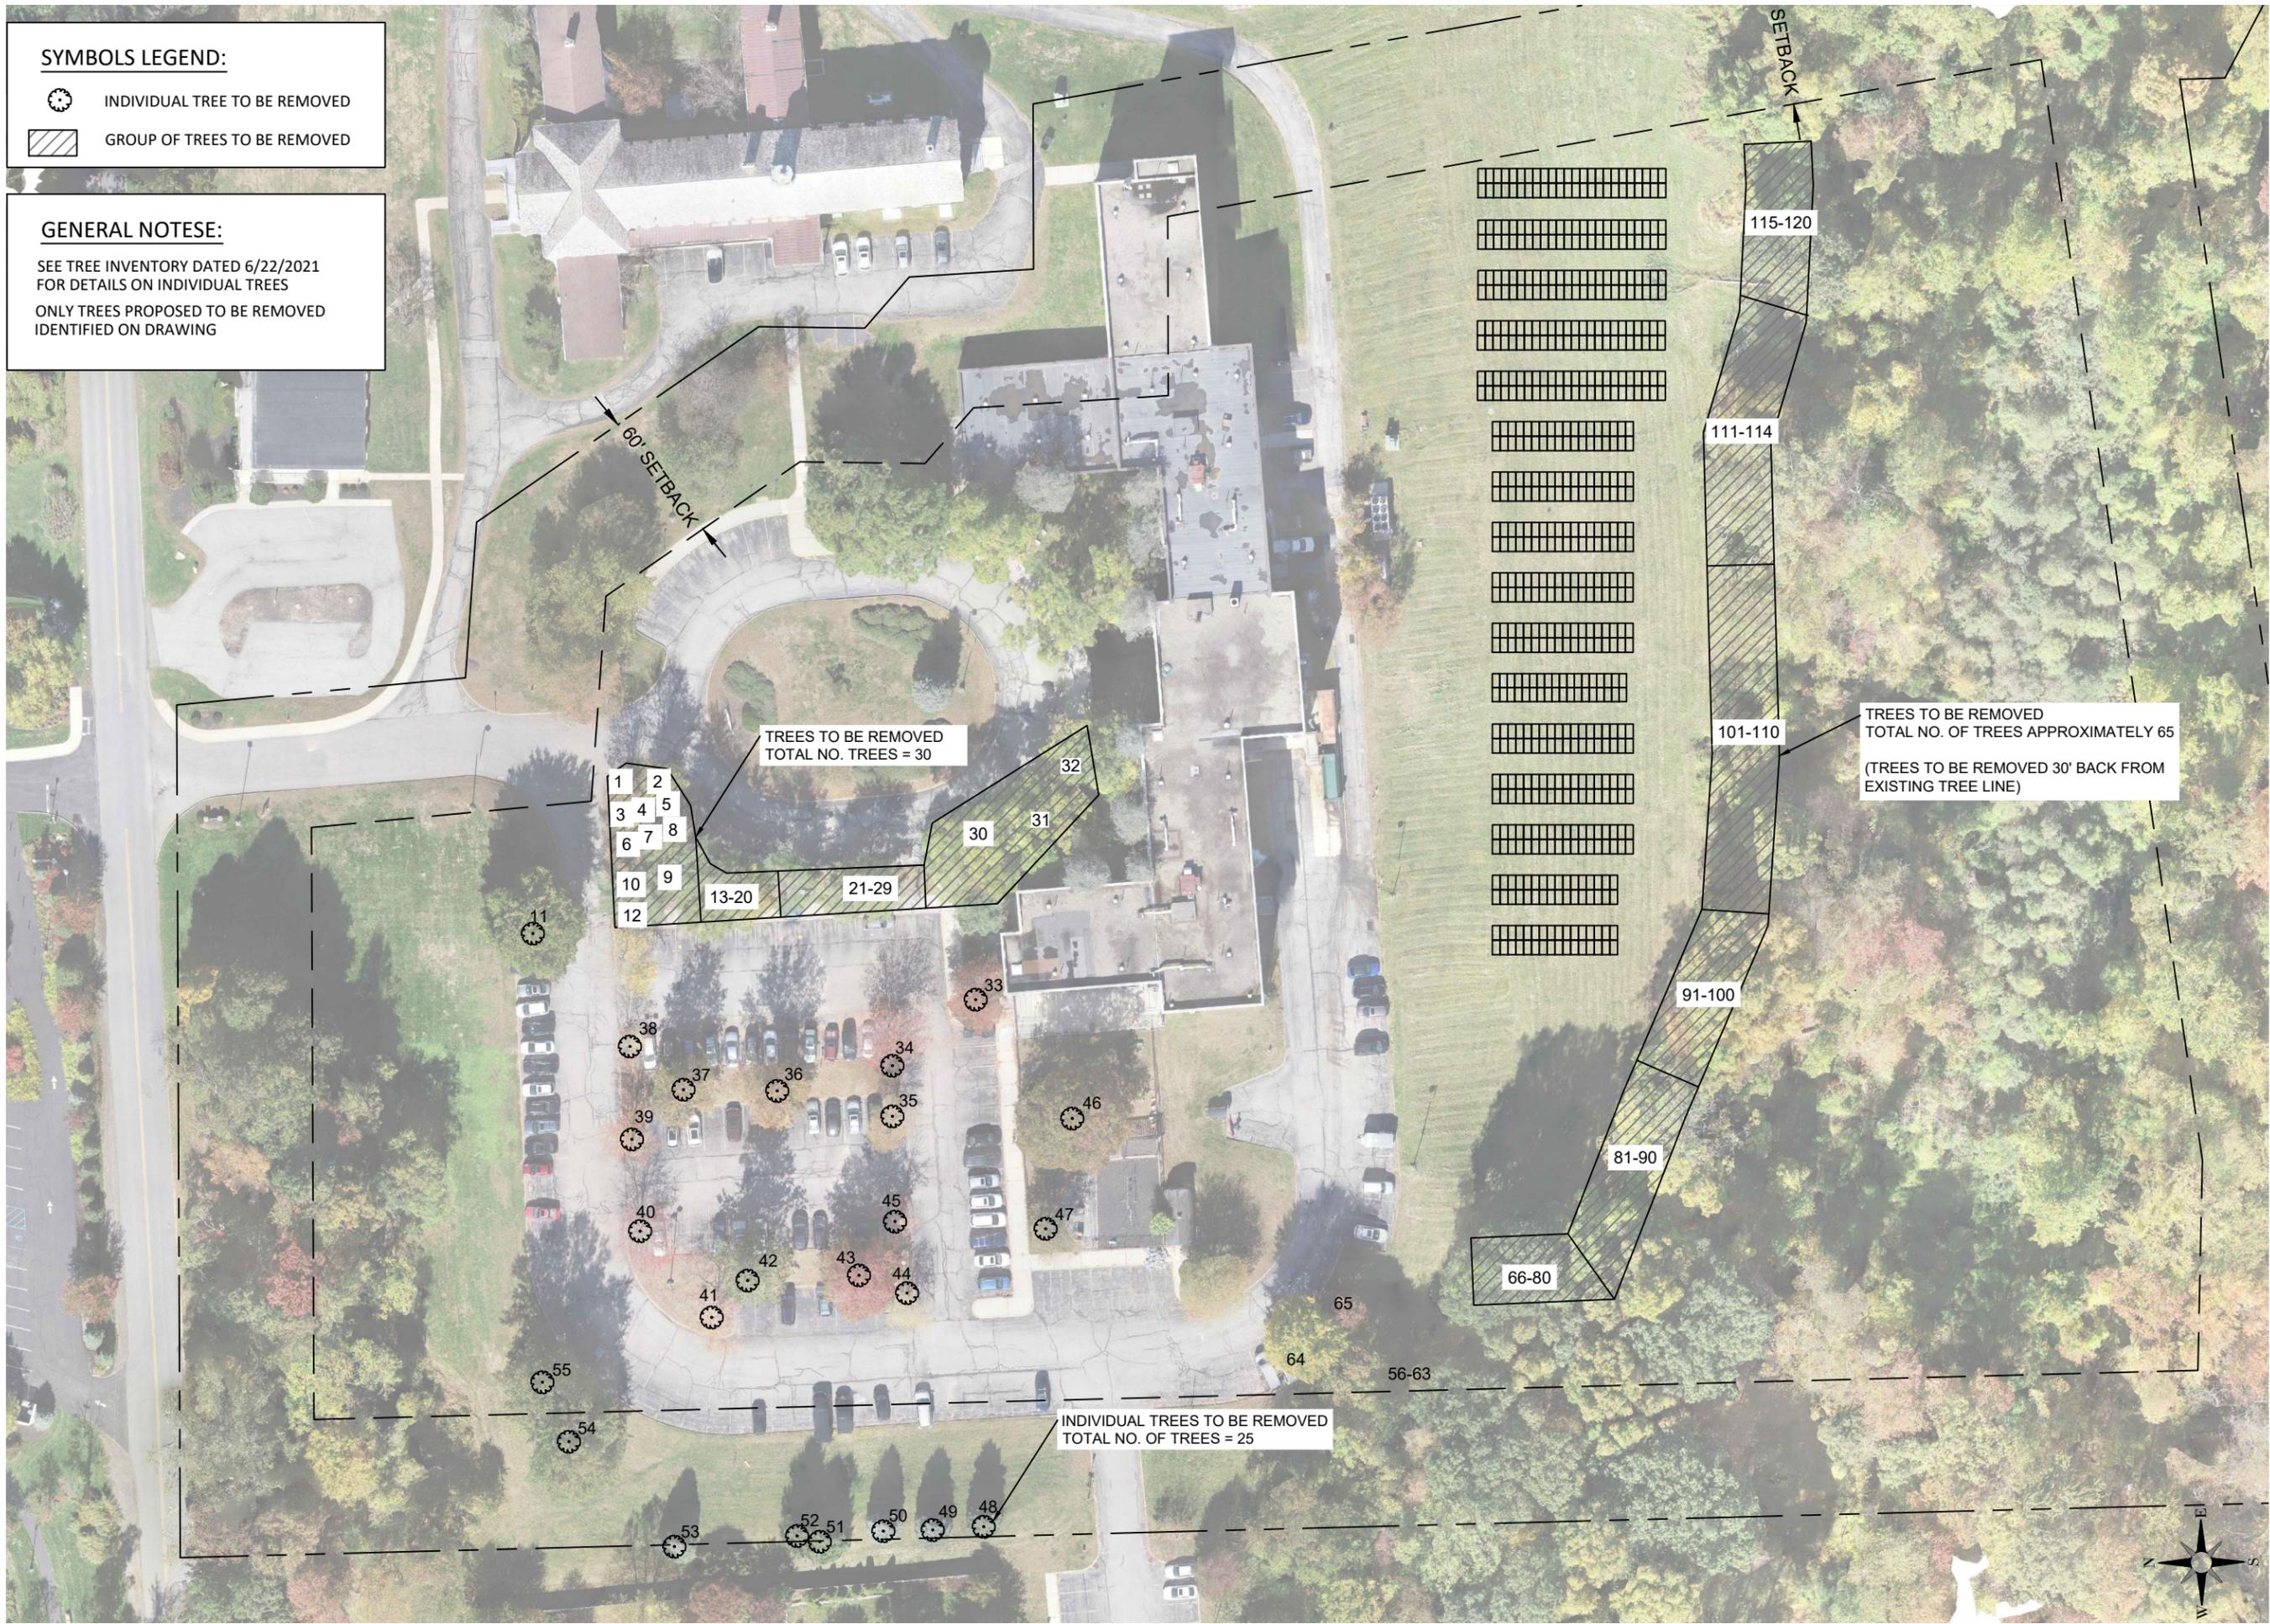

ECOGY ENERGY
 315 FLATBUSH AVENUE #393
 BROOKLYN, NY 11217
 assetmanagement@ecogyenergy.com
 (718)-304-0945

ECOGY NY XII LLC

Project Name:
**YORKTOWN RNC
 283.8 kW-DC PV SYSTEM
 GROUND MOUNT**

Project Site:
**2300 CATHERINE STREET
 YORKTOWN, NY 10598**

Account No: xxxxx
 New Service Case #: xxxxx

#	REVISION DESCRIPTION	DATE	BY

Professional Stamp

Professional Stamp area (blank)

SHEET NAME:
**TREE WORK
 PLAN**

PROJECT NUMBER: XXXX
 DATE: 11/16/2020
 SHEET NUMBER: - of -

DRAWN BY: SCG
 CHECKED BY: [Signature]
 DWG. NUMBER: L-100